

## INDEX OF DRAWINGS

- 1 - 14 COVER SHEET
- 2 - 14 FOUNDATION DETAILS
- 3 - 14 CONCRETE SLAB PLAN
- 4 - 14 FLOOR PLAN
- 5 - 14 SCHEDULES
- 6 - 14 FRONT & REAR ELEVATIONS
- 7 - 14 LEFT & RIGHT ELEVATIONS
- 8 - 14 HEAD & JAMB DETAILS
- 9 - 14 WALL SECTIONS
- 10 - 14 WALL SECTIONS
- 11 - 14 ROOF FRAMING PLAN
- 12 - 14 MECHANICAL PLAN
- 13 - 14 ELECTRICAL PLAN
- 14 - 14 ELECTRICAL PANEL

# MISSOURI DEPARTMENT OF TRANSPORTATION

NEW POLE BARN IN SOUTHEAST DISTRICT

HAYTI, MISSOURI 63830  
429 Missouri State Outer Road  
PEMISCOT COUNTY

## CODE REQUIREMENTS

BUILDING CODE - CURRENT IBC  
MECHANICAL CODE - CURRENT N.E.C.  
ELECTRICAL CODE - CURRENT N.E.C.

## ALTERNATE CONDITIONS:


THE VARYING MAKEUP OF SOILS AND OCCURRENCE OF ROCK IN MANY MODOT DISTRICTS MAY REQUIRE CONSIDERABLE REDESIGN OF THE POST PLACEMENT BELOW GRADE FROM THAT SHOWN IN THESE DRAWINGS. THE BIDDER WILL BE RESPONSIBLE FOR OBTAINING ACCURATE INFORMATION FROM THE DISTRICTS FACILITIES MANAGER (I.E. DRILLINGS OR BORINGS INFORMATION 5'-0" DEEP AT EACH BUILDING CORNER AND AT LEAST ONE INTERMEDIATE SAMPLE TO THIS DEPTH ON THE LONG SIDES OF THE PROPOSED STRUCTURE) SO THAT THE BID WILL REFLECT ANY FOUNDATION REQUIREMENTS BEYOND THOSE SHOWN HERE. INFORMATION COULD INCLUDE PREVIOUS EXCAVATIONS THAT VERIFY FOOTING CONDITIONS THAT WILL BE ENCOUNTERED BY THIS CONTRACTOR.

## REQUIRED BUILDING ELEMENTS:

2 x 6 WALL GIRTS - #2 SYP OR EQUAL.  
FINISH COAT ON 26 GAUGE METAL SIDING TO BE FLOUROPOLYMER (KYNAR 500 OR EQUAL. POLYESTER IS NOT ACCEPTABLE.  
CONNECTION OF ROOF TRUSS TO POST OR HEADER TO BE EQUAL TO SIMPSON TIE #HD-1 OR HD2A.  
POSTS TO BE A MINIMUM OF 4'-0" BELOW GRADE IN COMPACTED SOIL.

## FABRICATOR NOTES:

THESE DRAWINGS ARE FURNISHED AS A GUIDE TO BIDDERS IN SUBMITTING THE COMPLETE PACKAGE OF DETAILED DRAWINGS OF THEIR PROPOSED STRUCTURE TO BE SEALED BY AN ARCHITECT/ENGINEER. WHERE "AS REQUIRED" IS USED THE BIDDER MUST FURNISH A DETAILED DESCRIPTION OF THE BUILDING ELEMENT TO BE FURNISHED.

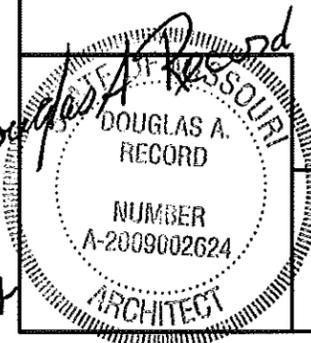

COVER SHEET

MISSOURI DEPARTMENT  
OF TRANSPORTATION

DIVISION OF GENERAL SERVICES  
FACILITIES MANAGEMENT

New Pole Barn in Southeast District  
HAYTI, MISSOURI  
Pemiscot County

DRAWN BY: LARRY CASPER  
CHECKED BY: DOUG RECORD  
DATE: 4-22-14  
Sheet  
1 of 14


### GRADING NOTES

CONTRACTOR WILL BE RESPONSIBLE FOR:


- EXCAVATION OF THE SUB GRADE.
- EXCAVATING OF FOOTINGS.
- ALL BACK FILL MATERIAL INSIDE AND OUTSIDE NEW BUILDING.
- CRUSHED ROCK BASE UNDER SLAB & ROCK IN OPEN BAYS.
- ALL FILL, BACK FILL & SUB GRADE MATERIAL AS REQUIRED.
- FINISHED GRADE TO DRAIN AWAY FROM BUILDINGS.
- PROVIDE TOP SOIL, FERTILIZE, SEED AND STRAW AT ALL THE LAWN AREAS DISTURBED DURING CONSTRUCTION.
- PROVIDE FINISHED GRADE MATERIAL DISTURBED DURING CONSTRUCTION TO MATCH EXISTING.
- VERIFY UTILITY LOCATIONS BEFORE CONSTRUCTION.

### CONCRETE NOTES


1. CONCRETE WORK SHALL BE EXECUTED IN STRICT COMPLIANCE WITH THE LATEST EDITION OF THE AMERICAN CONCRETE INSTITUTE (A.C.I.) MANUAL OF CONCRETE PRACTICE.
2. FOUNDATION DESIGN IS BASED UPON AN ASSUMED SOIL BEARING CAPACITY OF 2000 PSF. IF WET OR UNUSUAL SOIL CONDITIONS ARE ENCOUNTERED, NOTIFY THE DESIGNER AND CONSTRUCTION INSPECTOR BEFORE PROCEEDING WITH THE WORK.
3. IF CONDITIONS REQUIRING ROCK EXCAVATION ARE ENCOUNTERED, NOTIFY THE DESIGNER AND CONSTRUCTION INSPECTOR BEFORE PROCEEDING WITH THE WORK.
4. ALL CONCRETE SHALL BE TYPE 1 CEMENT WITH A COMPRESSIVE STRENGTH OF 4,000 PSI @ 28 DAYS WITH 4" SLUMP.
5. CONCRETE EXPOSED TO THE EXTERIOR SHALL RECEIVE AIR ENTRAINMENT 6% +/- 2%.
6. DEFORMED STEEL REINFORCING BARS SHALL BE: #4 AND LARGER ASTM A615 GRADE 60.
7. SEE SPECIFICATION SECTION 03300 CONCRETE FOR ADDITIONAL INFORMATION.
8. SAWED CONTROL JOINTS SHALL BE CLEANED FREE OF ALL DEBRIS AND FILLED WITH SEALANT. SEE SECTION 07900.

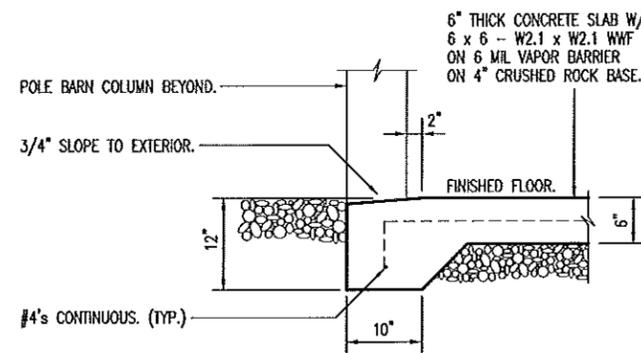


**A**  
2  
GARAGE DOOR  
**EXTERIOR SLAB**  
SCALE: 1/2" = 1'-0"

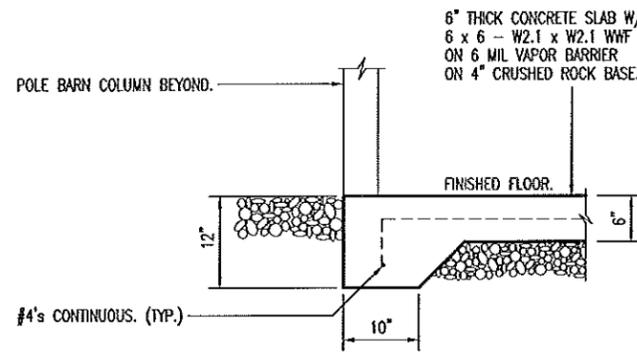

**B**  
2  
**FLOOR SLAB EDGE**  
SCALE: 1/2" = 1'-0"

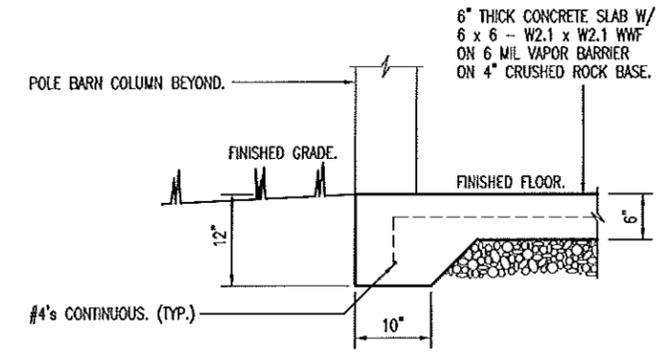

**C**  
2  
**FLOOR SLAB EDGE**  
SCALE: 1/2" = 1'-0"

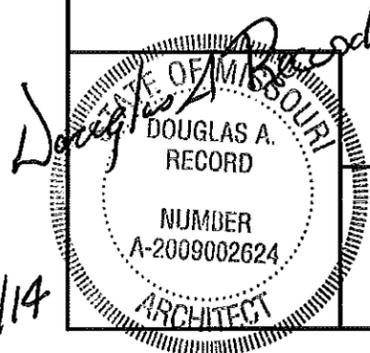


## FOUNDATION DETAILS



MISSOURI DEPARTMENT  
OF TRANSPORTATION  
DIVISION OF GENERAL SERVICES  
FACILITIES MANAGEMENT

New Pole Barn in Southeast District  
HAYTI, MISSOURI  
Pemiscot County

DRAWN BY: LARRY CARMER  
CHECKED BY: DOUG RECORD  
DATE: 4-22-14  
Sheet  
2 of 14

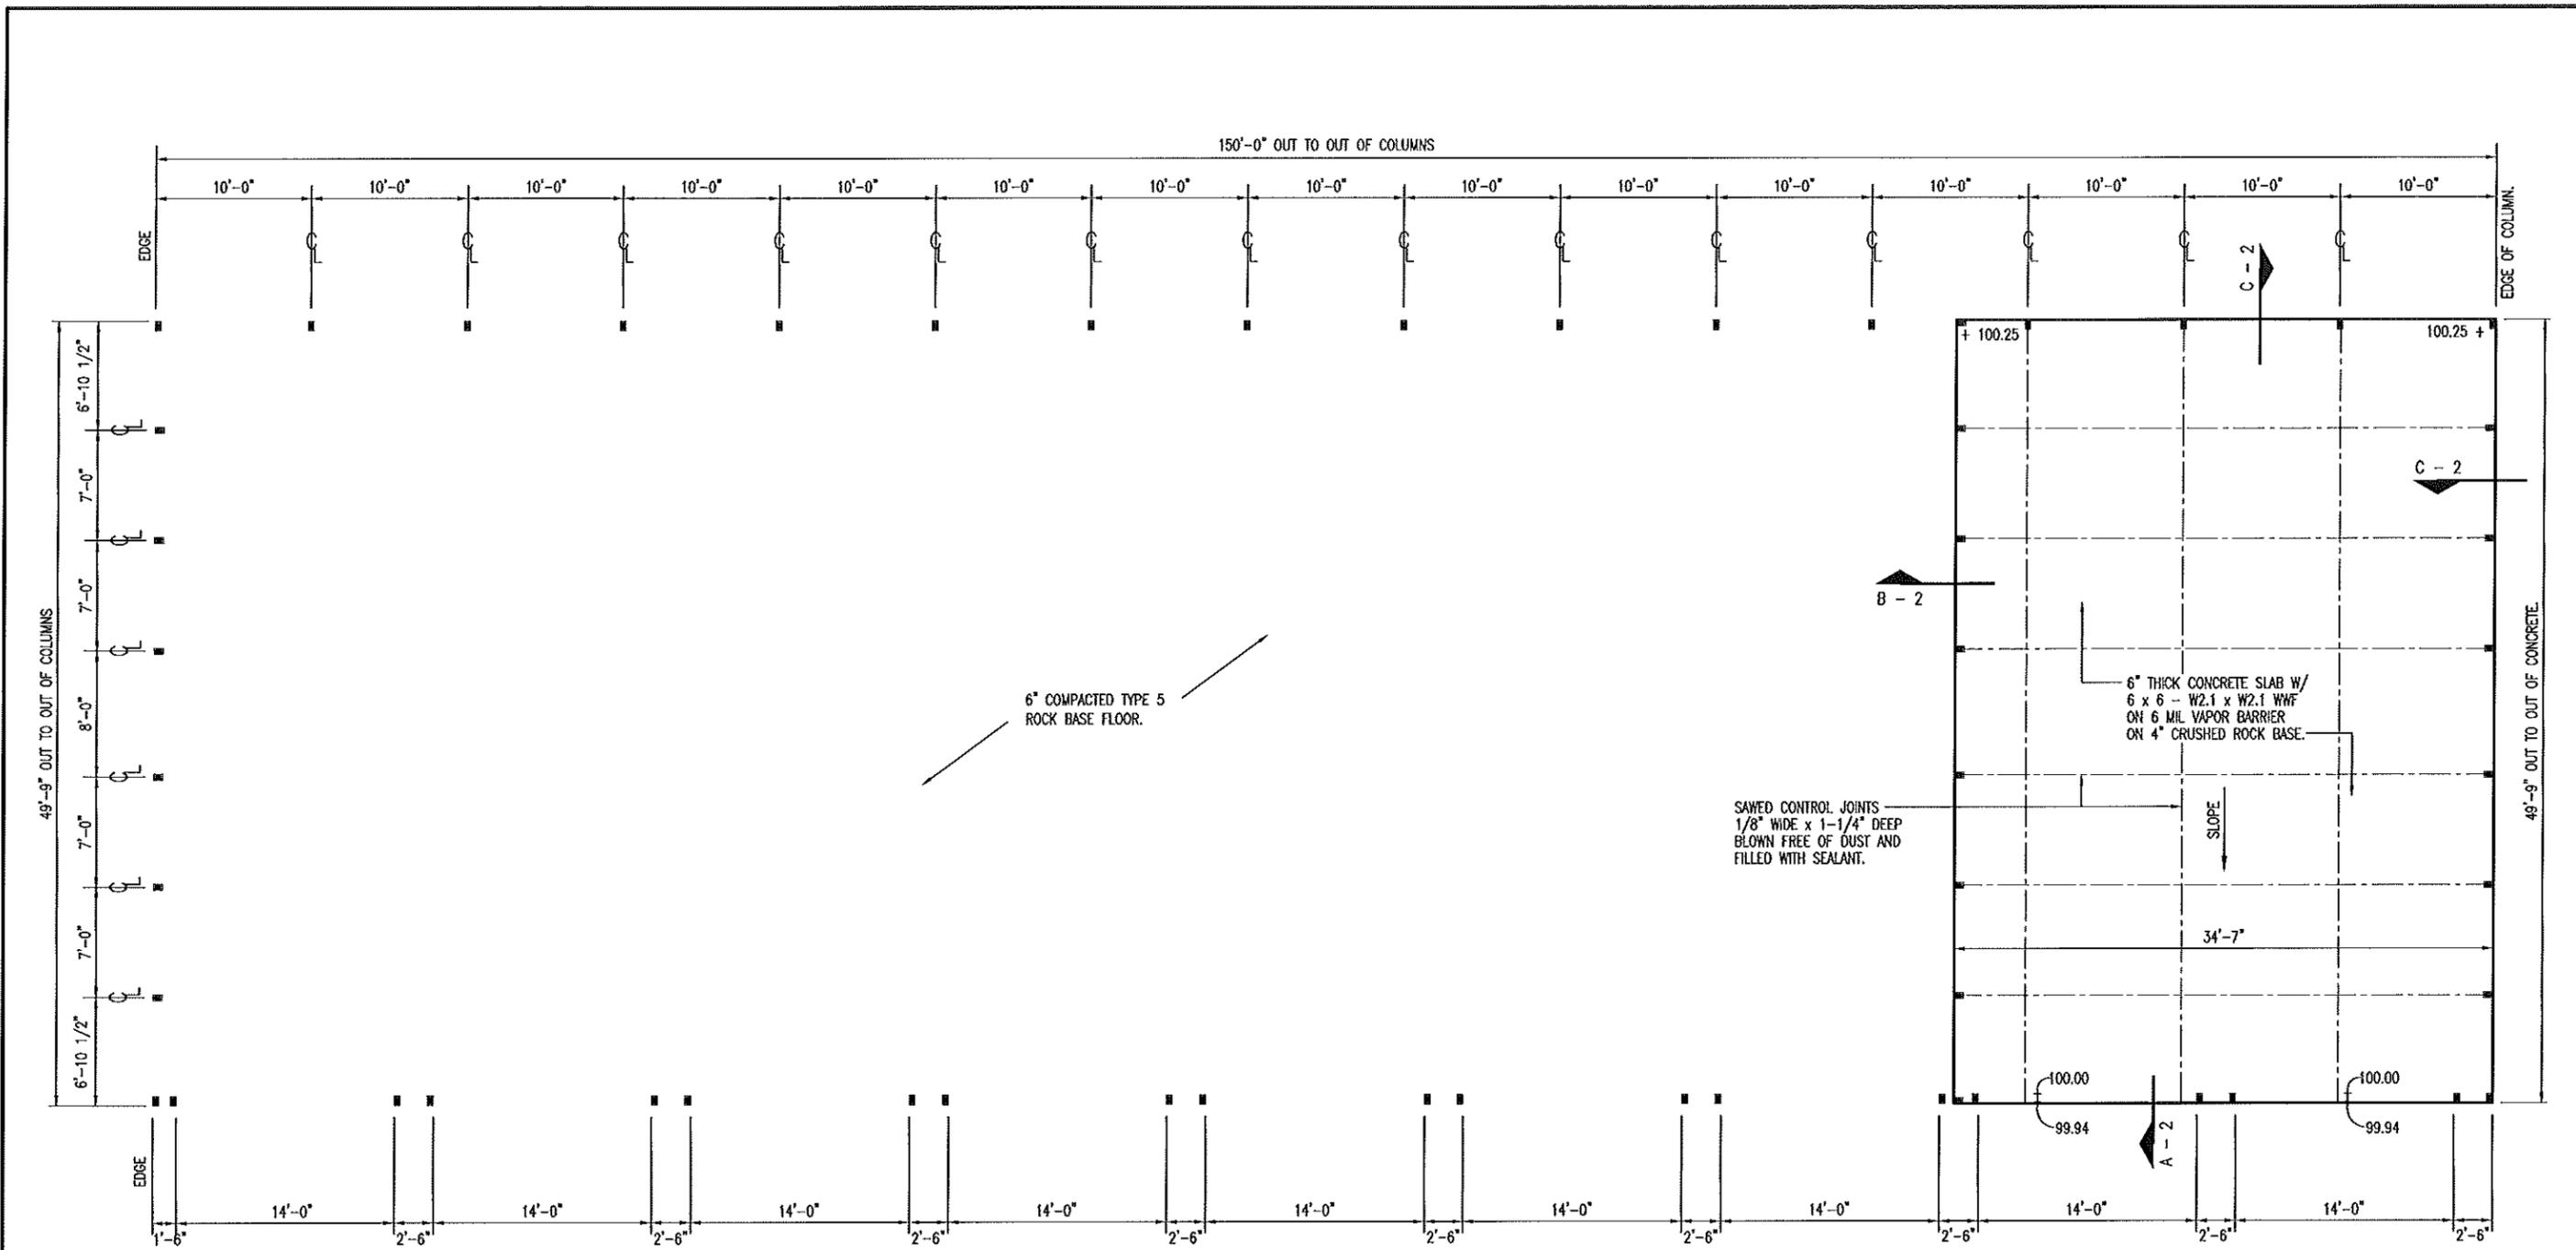

 **A**  
**3** CONCRETE SLAB PLAN  
SCALE: 3/32" = 1'-0"

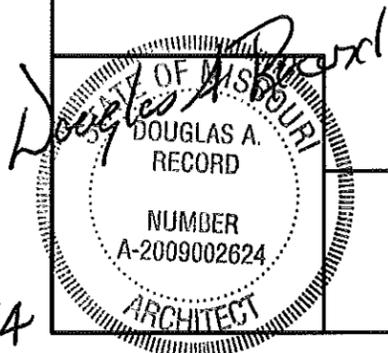


4/23/14

**CONCRETE SLAB PLAN**



**MISSOURI DEPARTMENT OF TRANSPORTATION**  
DIVISION OF GENERAL SERVICES  
FACILITIES MANAGEMENT

New Pole Barn in Southeast District  
HAYTI, MISSOURI  
Pemiscot County

DRAWN BY: LASSY CASPER
CHECKED BY: DOUG RECORD
DATE: 4-22-14
Sheet 3 of 14

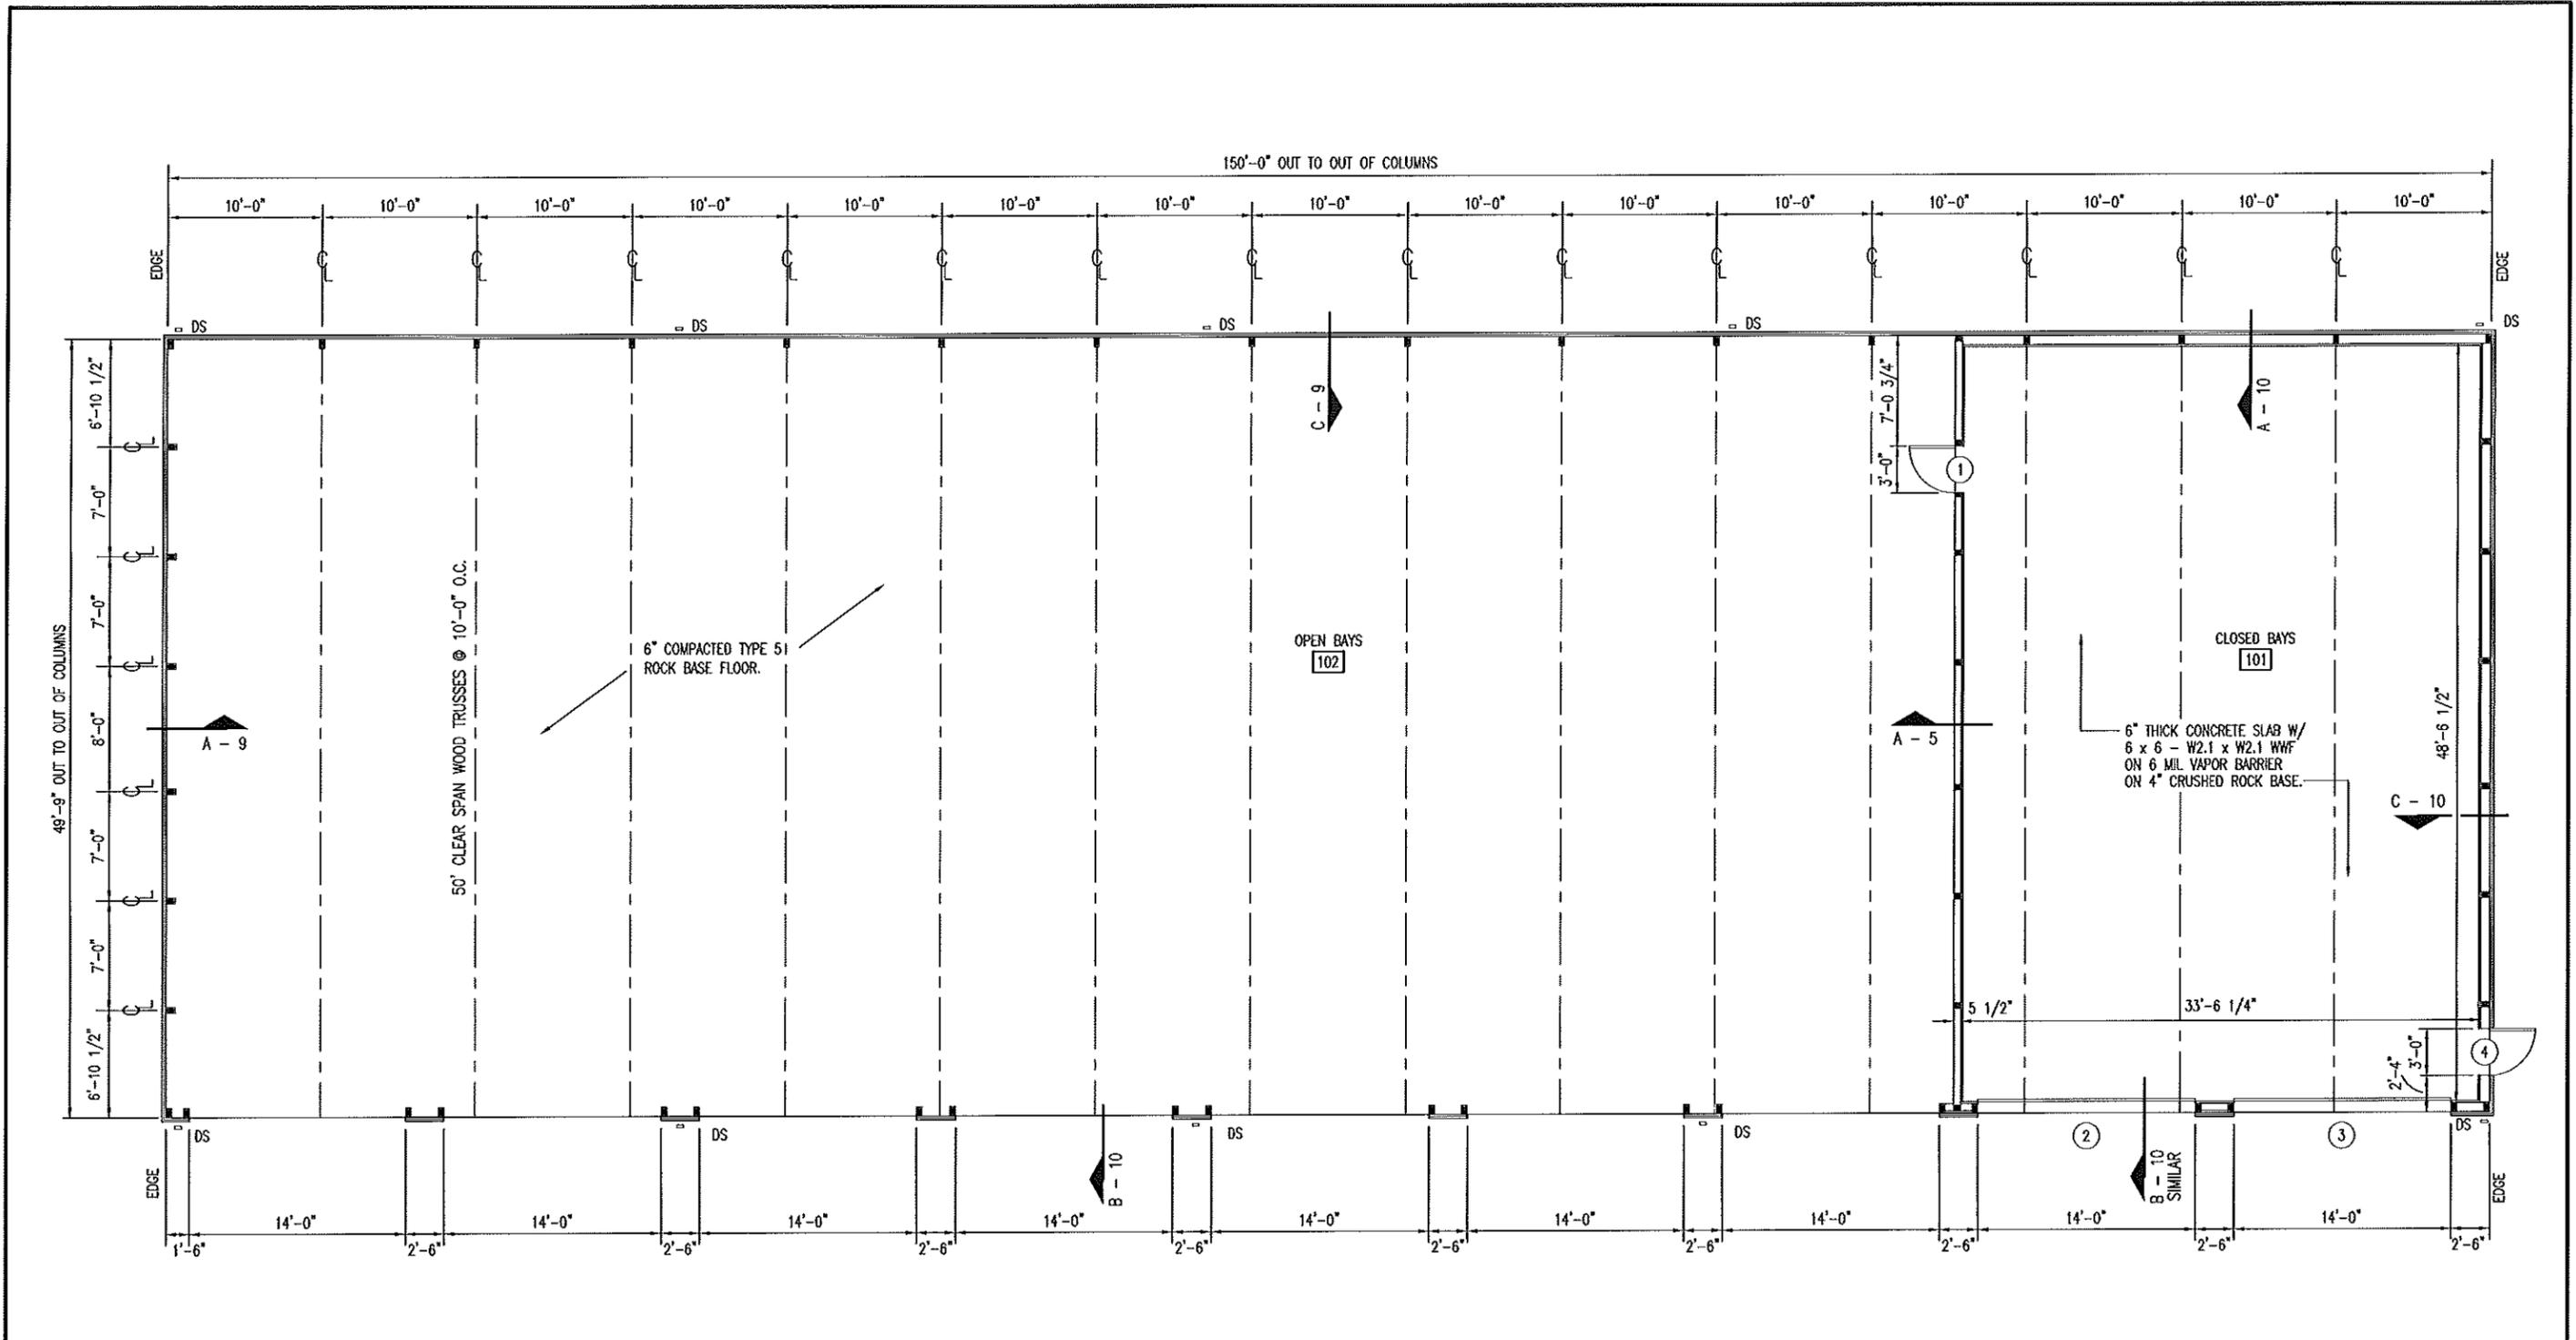

A FLOOR PLAN  
4 SCALE: 3/32" = 1'-0"

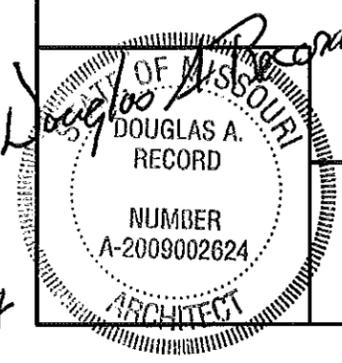 

FLOOR PLAN

MISSOURI DEPARTMENT  
OF TRANSPORTATION  
DIVISION OF GENERAL SERVICES  
FACILITIES MANAGEMENT

New Pole Barn in Southeast District  
HAYTI, MISSOURI  
Pemiscot County

DRAWN BY: LARRY CARMER  
CHECKED BY: DOUG RECORD  
DATE: 4-22-14  
Sheet  
4 of 14


### DOOR SCHEDULE

NO.	SIZE	SWING	DR. TYPE	FRM. TYPE	DETAIL	DEPTH	HDWR. GRP.
1	3'-0" x 7'-0" x 1-3/4"	LHR	A	I	C-8	6-1/2"	1
2	14'-0" x 14'-0" x 2"	-	B	-	A & B-8	-	-
3	14'-0" x 14'-0" x 2"	-	B	-	A & B-8	-	-
4	3'-0" x 7'-0" x 1-3/4"	RHR	A	I	F-8	6-1/2"	1

3'-0" x 7'-0" x 1-3/4"  
INSULATED HOLLOW METAL  
DOOR. PAINT PER  
SPECIFICATION.




TYPE A

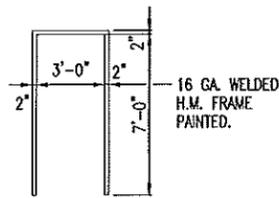

TYPE I

16 GA. WELDED  
H.M. FRAME  
PAINTED.

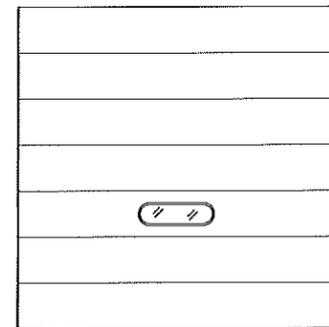

TYPE B

14'-0" x 14'-0" x 2"  
2" THICK, R-17.5, INSULATED  
PREFINISHED .016" METAL  
GARAGE DOOR WITH ONE  
INSULATED GLASS VIEW  
WINDOW. 26 GA. STEEL  
BACK COVER. WHITE BAKED  
ON POLYESTER TOP COAT  
PAINT ON BOTH SIDES.  
(TYPICAL)

### FINISH SCHEDULE


NO.	ROOM	FLOOR	WALLS	BASE	CEILING
		CURE AND SEALER ON CONCRETE.	6" COMPACTED TYPE 5 ROCK.	26 GA. INTERIOR PANELS 1/2" AC PLYWOOD. PAINTED.	NONE
101	CLOSED BAYS	●	●	●	●
102	OPEN BAYS WALL @ CLOSED BAYS	●	●	●	●

### HVAC SCHEDULE


SYM.	UNIT	MANUFACTURER	BTU OUTPUT	FUEL	VOLTAGE	REMARKS
A	18" DIA. SHUTTER MOUNT EXHAUST FAN W/WEATHERHOOD	DAYTON IHLAS & 3FKF2 OR EQUAL 5.4 AMPS	2,190 CFM	ELECTRIC	115	COMMERCIAL TYPEWALL EXHAUST FAN INCLUDES OSHA GUARD & SHUTTER. INCLUDE BIRD SCREEN AND GALVANIZED WEATHERHOOD.
B	GAS FIRED UNIT HEATER	REZNOR MODEL UDAP 200 OR EQUAL	166,000	PROPANE	115	SINGLE BURNER COMBUSTION, DIRECT SPARK IGNITION, 100% LOCK-OUT & CL-1 STANDARD HEATING ONLY THERMOSTAT.
C	MOTORIZED DAMPER	DAYTON MODEL 3C727 OR EQUAL .26 AMPS	---	ELECTRIC	115	24" MEDIUM GRADE, MOTORIZED, GALVANIZED STEEL DAMPER WITH 1/20 HP MOTOR. WIRE TO OPEN WHEN EXHAUST FAN IS TURNED ON.

### GENERAL NOTES:

BUILDING MANUFACTURER TO FURNISH ALL NECESSARY FLASHING AND TRIM TO PROVIDE A NEAT, WEATHERPROOF FIT AT ALL DOORS, COLUMNS AND ANY LOCATION WHERE THE METAL PANELS MAY BE CUT.

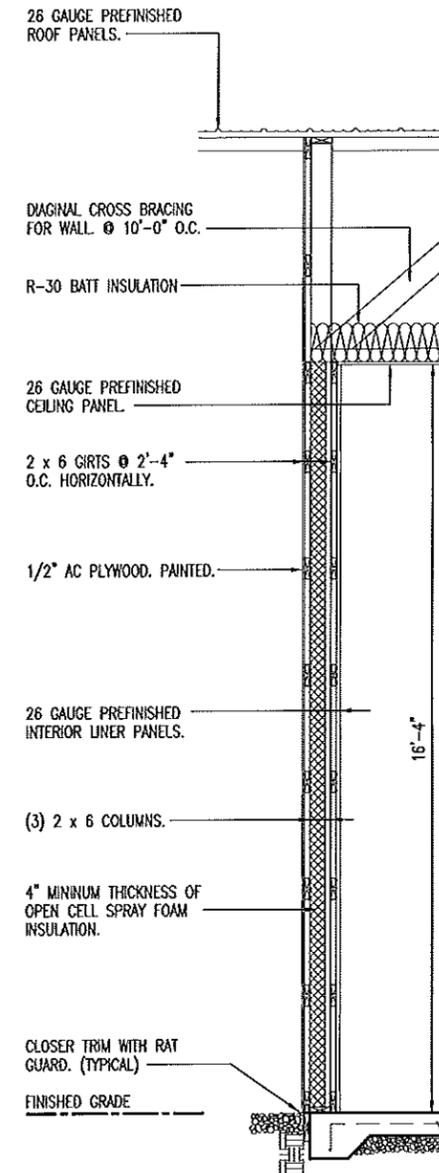

A MID-WALL SECTION  
5 SCALE: 1/4" = 1'-0"

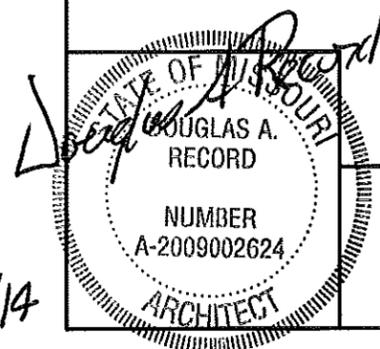


## SCHEDULES


MISSOURI DEPARTMENT  
OF TRANSPORTATION  
DIVISION OF GENERAL SERVICES  
FACILITIES MANAGEMENT

New Pole Barn in Southeast District  
HAYTI, MISSOURI  
Pemiscot County


DRAWN BY: LARRY CARYER  
CHECKED BY: DOUG RECORD  
DATE: 4-22-14  
Sheet  
5 of 14

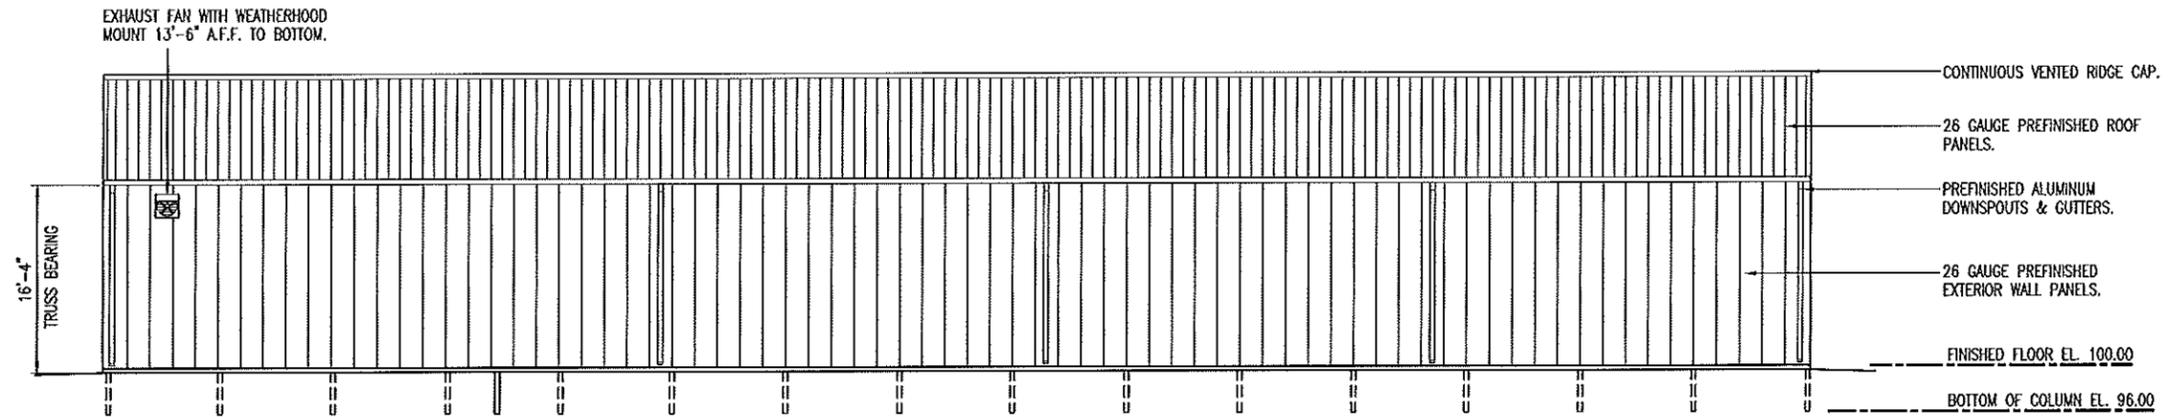

**B** REAR ELEVATION  
6 SCALE: 1/16" = 1'-0"

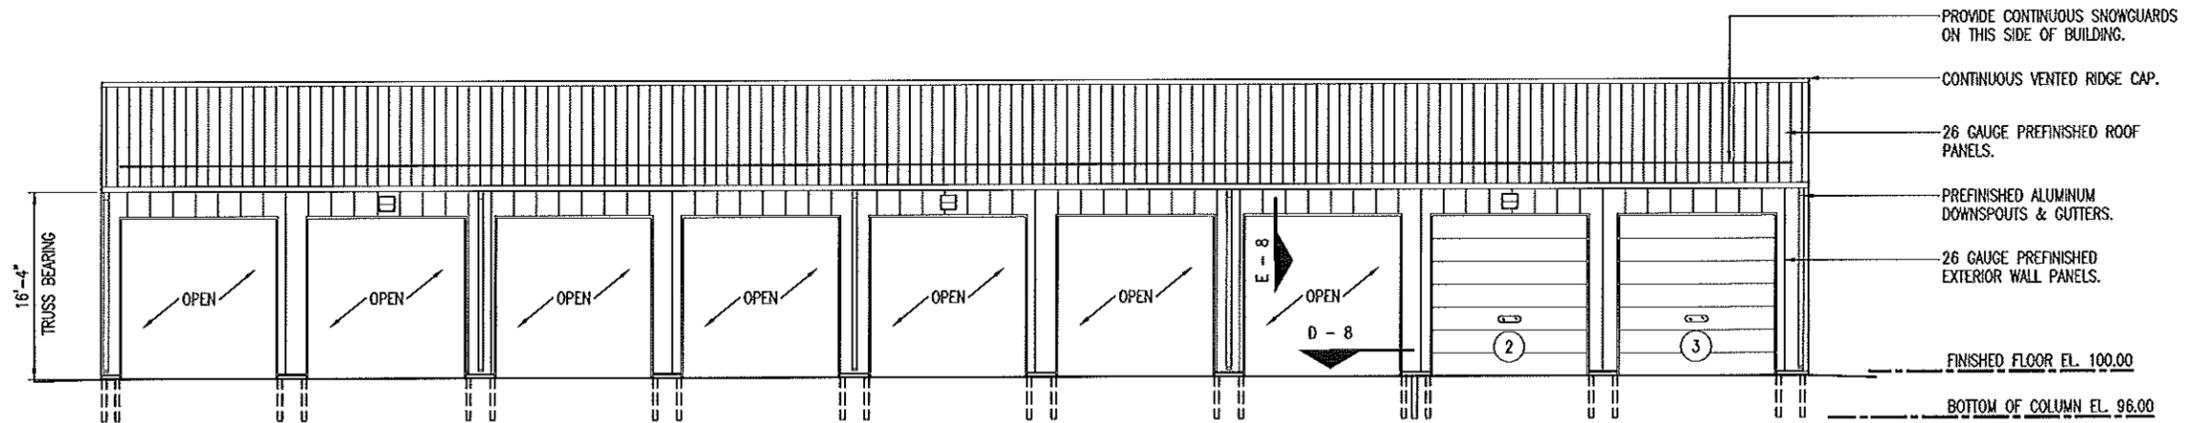

**A** FRONT ELEVATION  
6 SCALE: 1/16" = 1'-0"

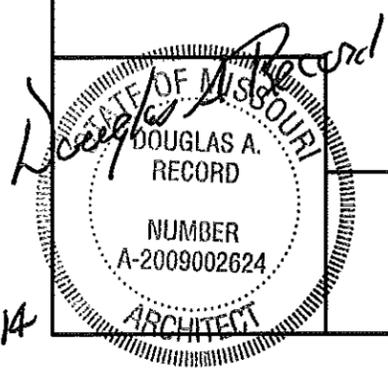


4/23/14

FRONT & REAR ELEVATIONS


MISSOURI DEPARTMENT  
OF TRANSPORTATION  
DIVISION OF GENERAL SERVICES  
FACILITIES MANAGEMENT

New Pole Barn in Southeast District  
HAYTI, MISSOURI  
Pemiscot County

DRAWN BY: LARRY CARVER  
CHECKED BY: DOUG RECORD  
DATE: 4-22-14  
Sheet  
6 of 14

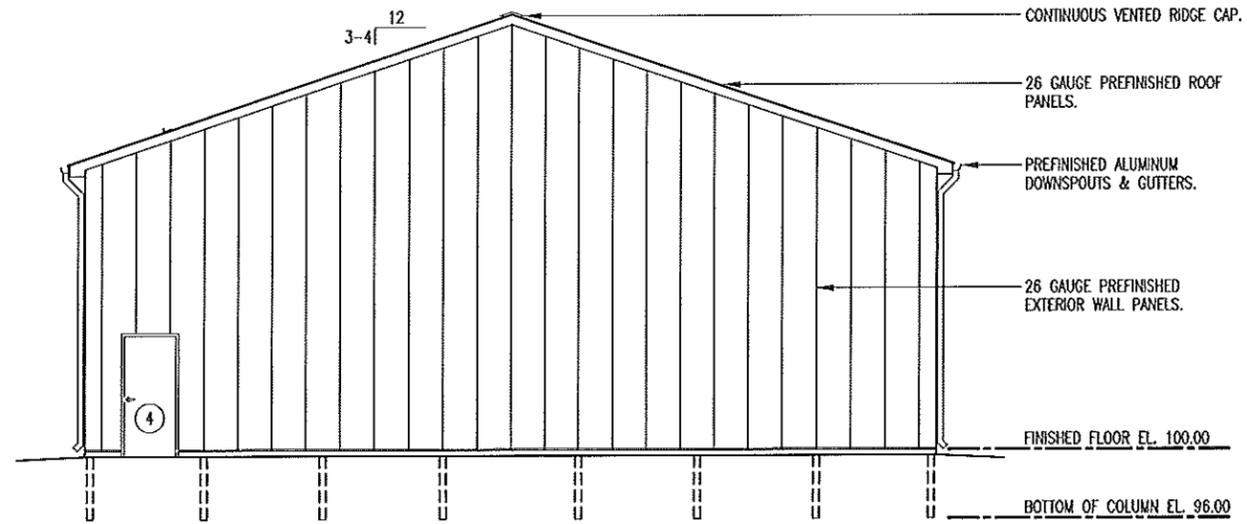

**B** RIGHT ELEVATION  
 7 SCALE: 3/32" = 1'-0"

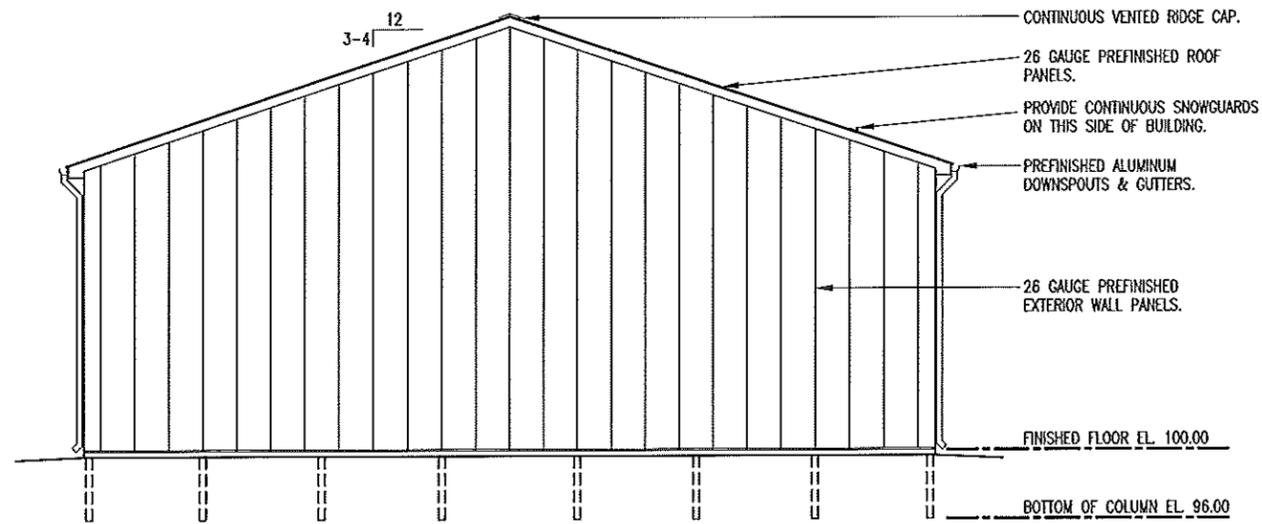

**A** LEFT ELEVATION  
 7 SCALE: 3/32" = 1'-0"

*Douglas A. Record*  
 MISSOURI  
 DOUGLAS A. RECORD  
 NUMBER  
 A-2009002624  
 ARCHITECT


LEFT & RIGHT ELEVATIONS

MISSOURI DEPARTMENT  
 OF TRANSPORTATION  
 DIVISION OF GENERAL SERVICES  
 FACILITIES MANAGEMENT


New Pole Barn in Southeast District  
 HAYTI, MISSOURI  
 Pemiscot County

DRAWN BY: LARRY CARVER  
 CHECKED BY: DOUG RECORD  
 DATE: 4-22-14  
 Sheet  
 7 of 14


4/23/14

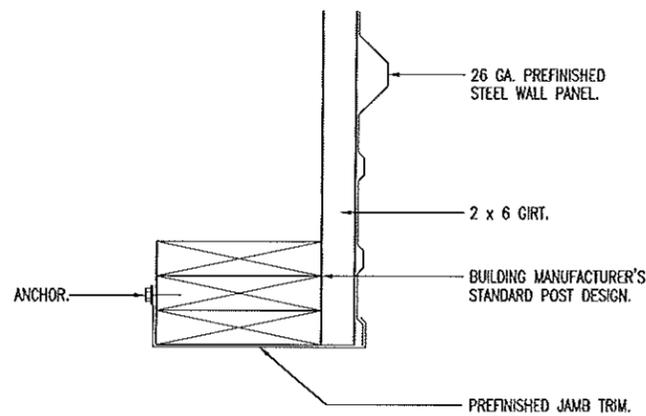


**D** GARAGE DOOR JAMB  
8 SCALE: 1-1/2" = 1'-0"

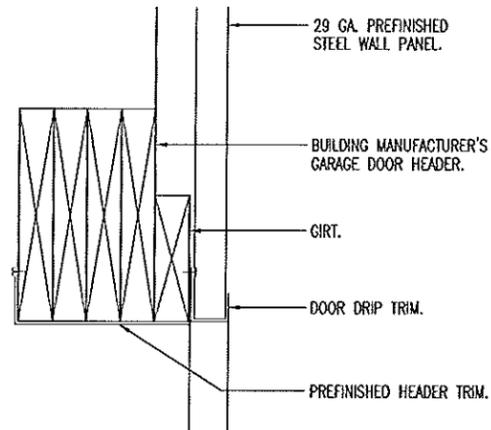


**E** GARAGE DOOR HEAD  
8 SCALE: 1-1/2" = 1'-0"

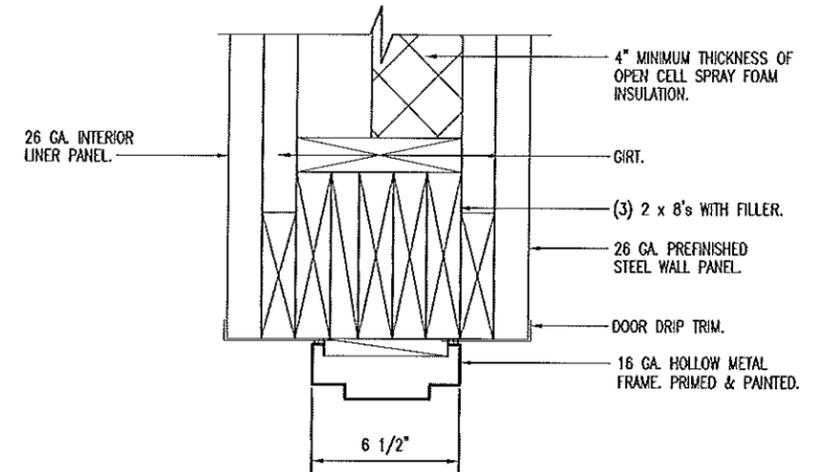


**F** DOOR HEADER/JAMB  
8 SCALE: 1-1/2" = 1'-0"

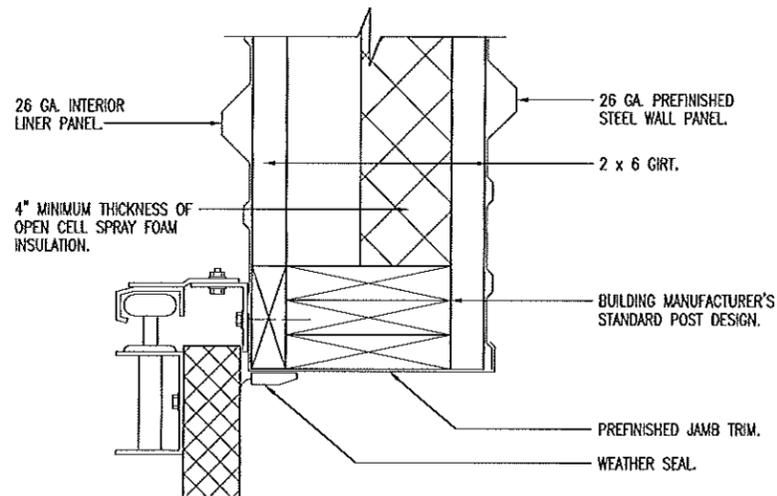

**A** GARAGE DOOR JAMB  
8 SCALE: 1-1/2" = 1'-0"

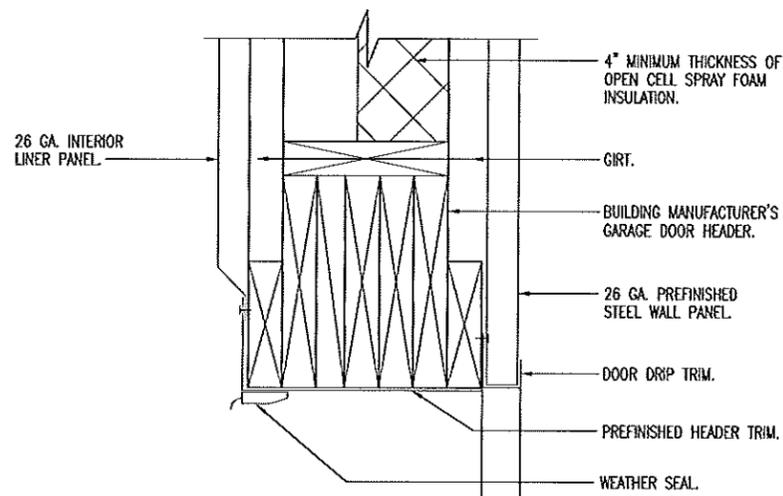

**B** GARAGE DOOR HEAD  
8 SCALE: 1-1/2" = 1'-0"

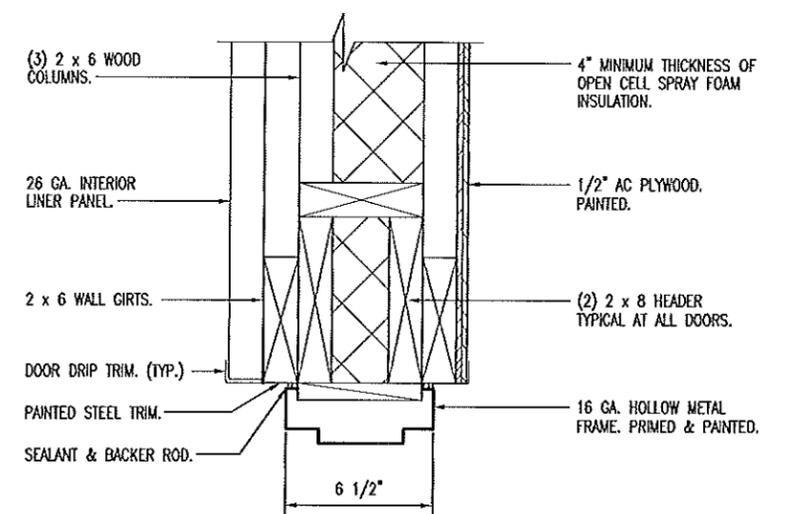

**C** DOOR HEADER/JAMB  
8 SCALE: 1-1/2" = 1'-0"

*Douglas A. Record*  
STATE OF MISSOURI  
DOUGLAS A. RECORD  
NUMBER  
A-2009002624  
ARCHITECT


4/23/14

HEAD & JAMB DETAILS


MISSOURI DEPARTMENT  
OF TRANSPORTATION  
DIVISION OF GENERAL SERVICES  
FACILITIES MANAGEMENT

New Pole Barn in Southeast District  
HAYTI, MISSOURI  
Pemiscot County


DRAWN BY: LARRY CARYER  
CHECKED BY: DOUG RECORD  
DATE: 4-22-14  
Sheet  
8 of 14

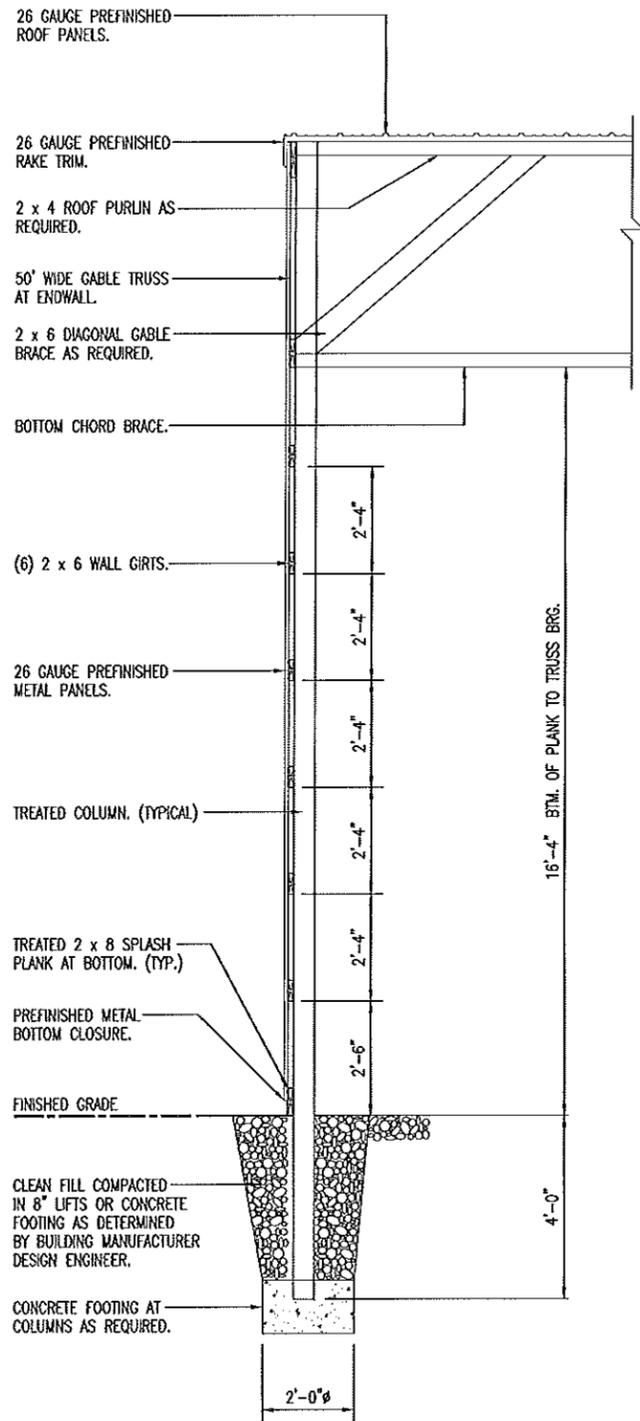


**A** ENDWALL SECTION  
 9 SCALE: 1/4" = 1'-0"

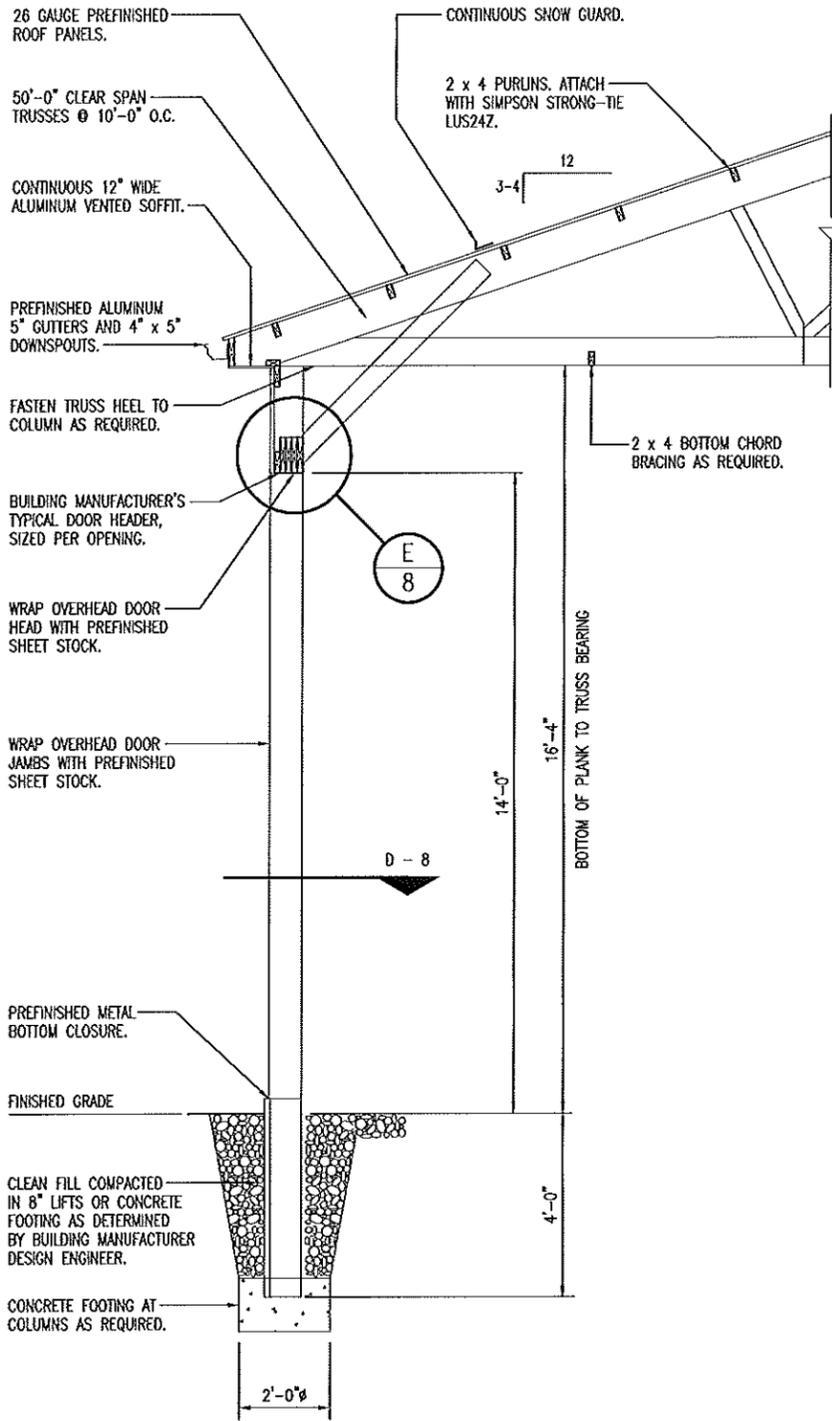

**B** OPEN OVERHEAD DOOR SECTION  
 9 SCALE: 1/4" = 1'-0"

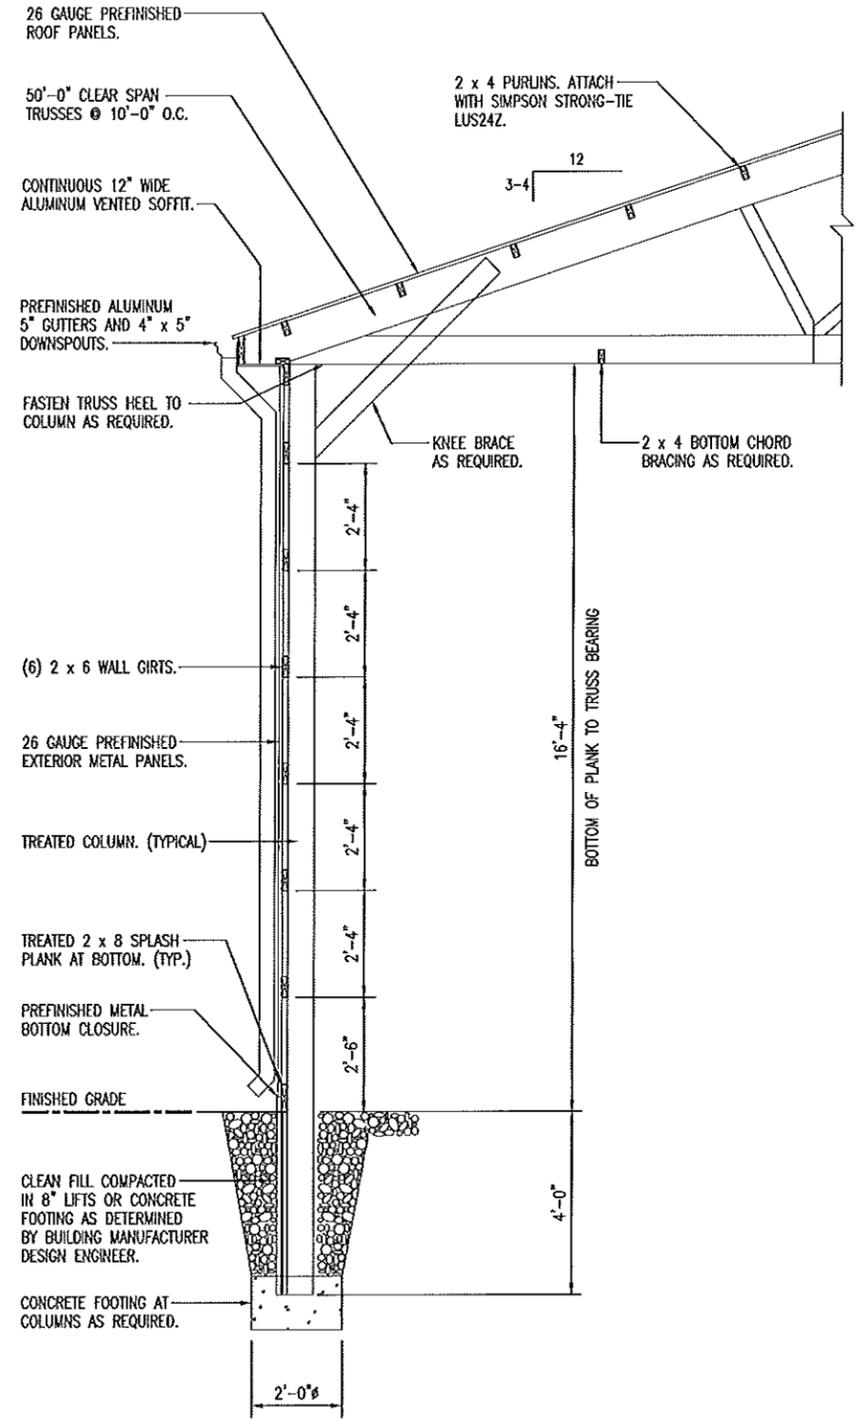

**C** SIDEWALL SECTION  
 9 SCALE: 1/4" = 1'-0"

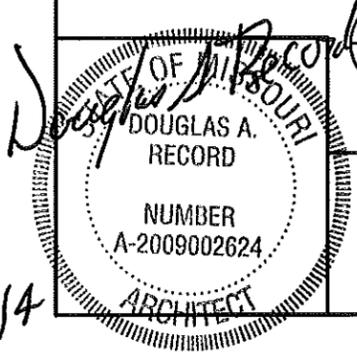



WALL SECTIONS

MISSOURI DEPARTMENT OF TRANSPORTATION  
 DIVISION OF GENERAL SERVICES FACILITIES MANAGEMENT

New Pole Barn in Southeast District  
 HAYTI, MISSOURI  
 Pemiscot County

DRAWN BY: LARRY CARVER  
 CHECKED BY: DOUG RECORD  
 DATE: 4-22-14  
 Sheet 9 of 14


4/23/14

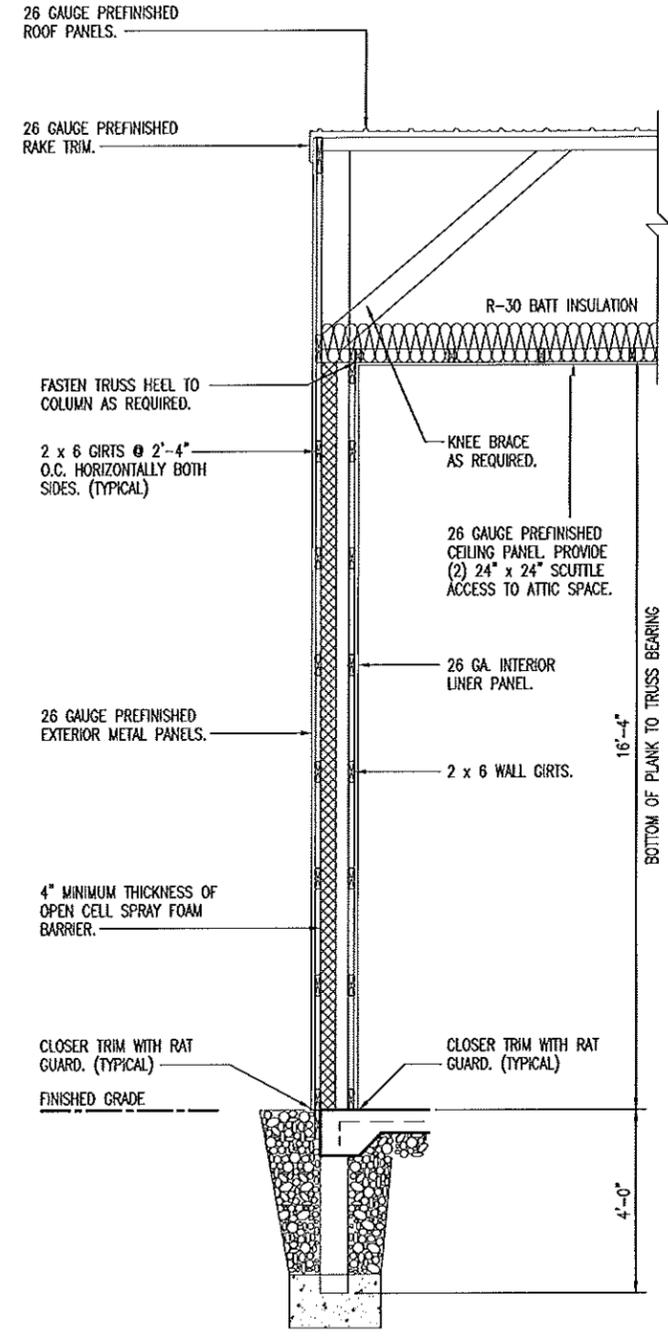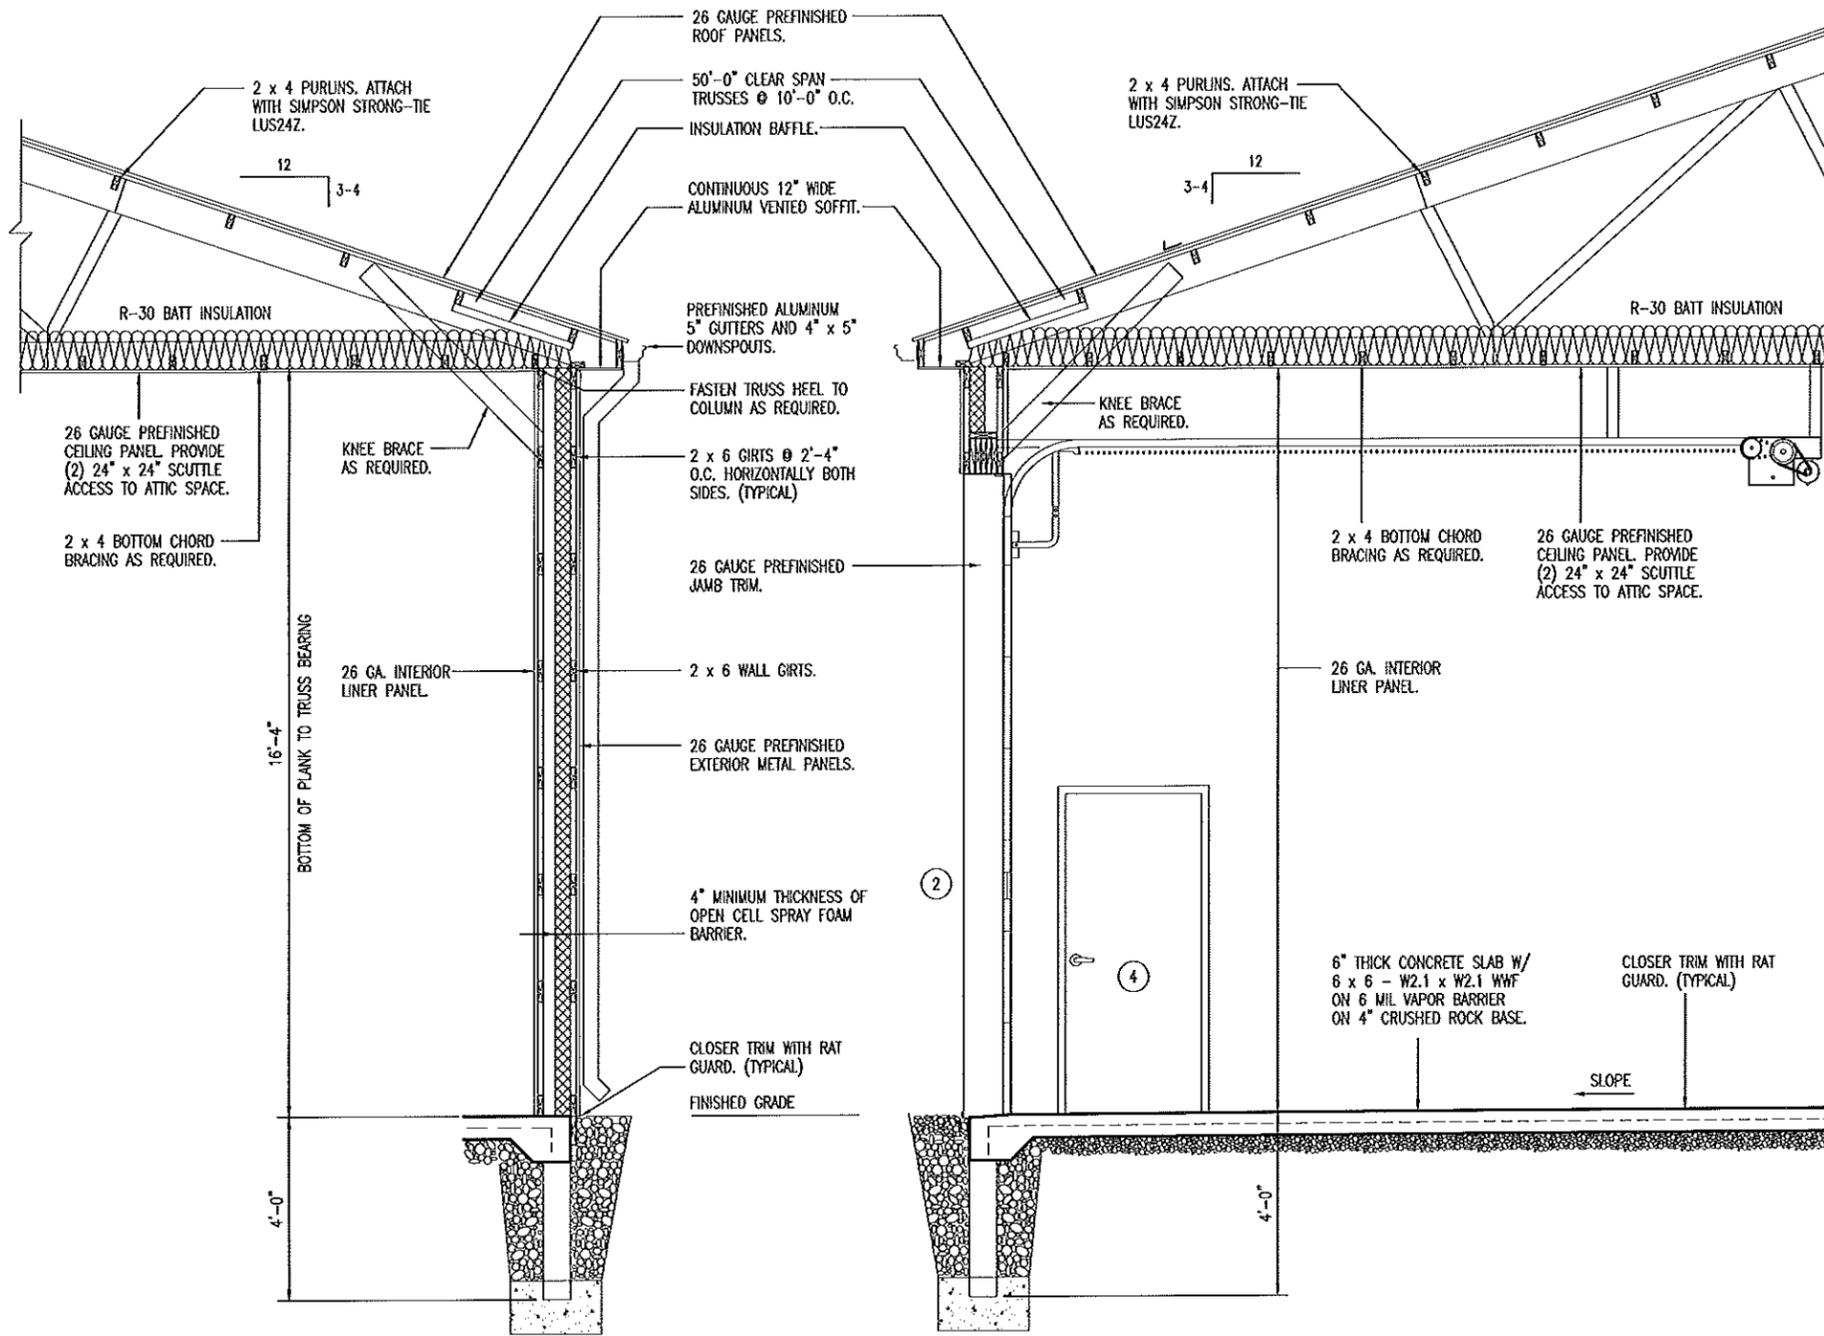

**A** SIDEWALL SECTION  
10 SCALE: 1/4" = 1'-0"

**B** OVERHEAD DOOR SECTION  
10 SCALE: 1/4" = 1'-0"

**C** ENDWALL SECTION  
10 SCALE: 1/4" = 1'-0"

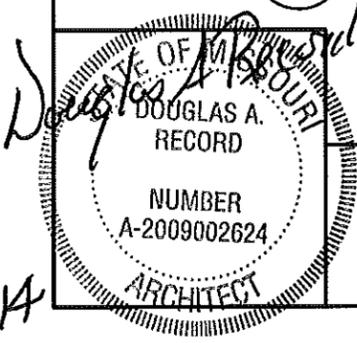

WALL SECTIONS

MISSOURI DEPARTMENT  
OF TRANSPORTATION  
DIVISION OF GENERAL SERVICES  
FACILITIES MANAGEMENT

New Pole Barn in Southeast District  
HAYTI, MISSOURI  
Pemiscot County


DRAWN BY: LARRY CARYER  
CHECKED BY: DOUG RECORD  
DATE: 4-22-14  
Sheet  
10 of 14




# MECHANICAL NOTES

1. DRAWINGS AND DIAGRAMS ARE DIAGRAMMATIC AND SHALL NOT BE SCALED. REFER TO ARCHITECTURAL DRAWINGS FOR DIMENSIONS.
2. MECHANICAL WORK SHALL BE INSTALLED IN STRICT COMPLIANCE WITH THE LATEST EDITION OF THE IBC MECHANICAL CODE.
3. PROVIDE EQUIPMENT AND APPURTENANCES NOT NECESSARILY SHOWN OR SPECIFIED BUT NEEDED FOR COMPLETE AND PROPER INSTALLATION.
4. ALL EQUIPMENT AND MATERIALS, IN PARTICULAR VALVES, FILTERS, MOTORS, AND CONTROLS SHALL BE ARRANGED TO PROVIDE PROPER CLEARANCE FOR SERVICE, MAINTENANCE, AND INSPECTION.
5. MECHANICAL SUBCONTRACTOR SHALL FULLY COORDINATE ALL WORK WITH PLUMBING AND ELECTRICAL WORKERS PRIOR TO COMMENCING OF THE MECHANICAL INSTALLATION.
6. PROVIDE BLOCKING TO HVAC DEVICES AS REQUIRED FOR A SECURE APPLICATION.
7. GAS LINE TO UNIT HEATER BY MECHANICAL CONTRACTOR FOR A FUNCTIONAL SYSTEM FROM PROPANE TANK.

SEE HVAC SCHEDULE SHEET 5.

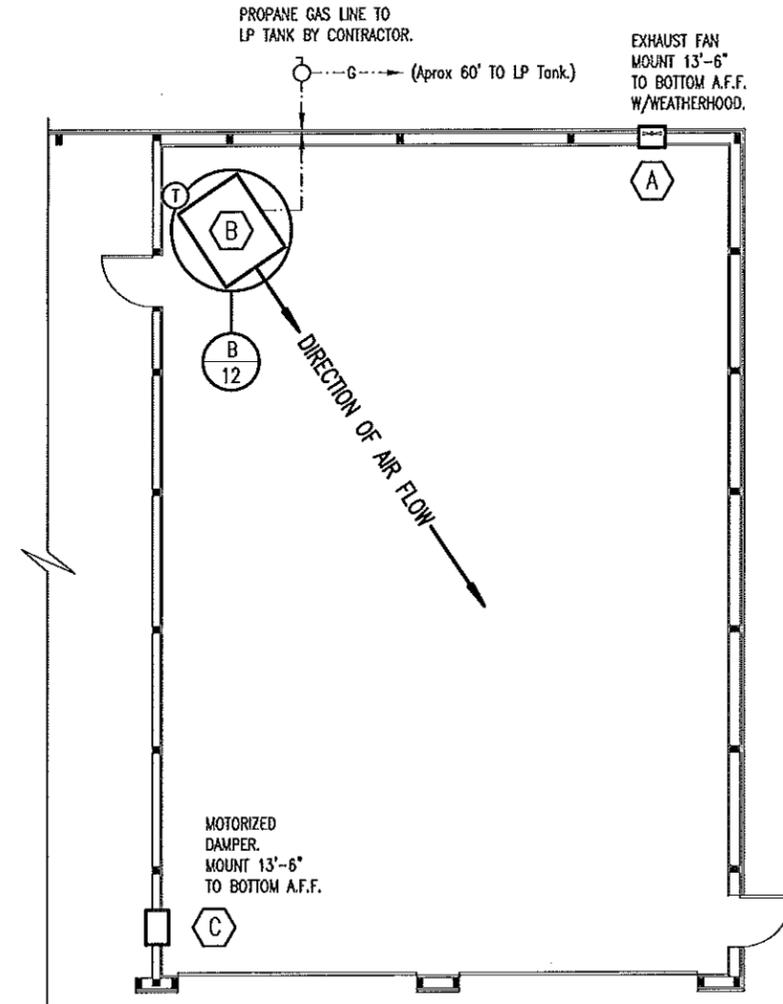

**A** MECHANICAL PLAN  
SCALE: 3/32" = 1'-0"  
NORTH

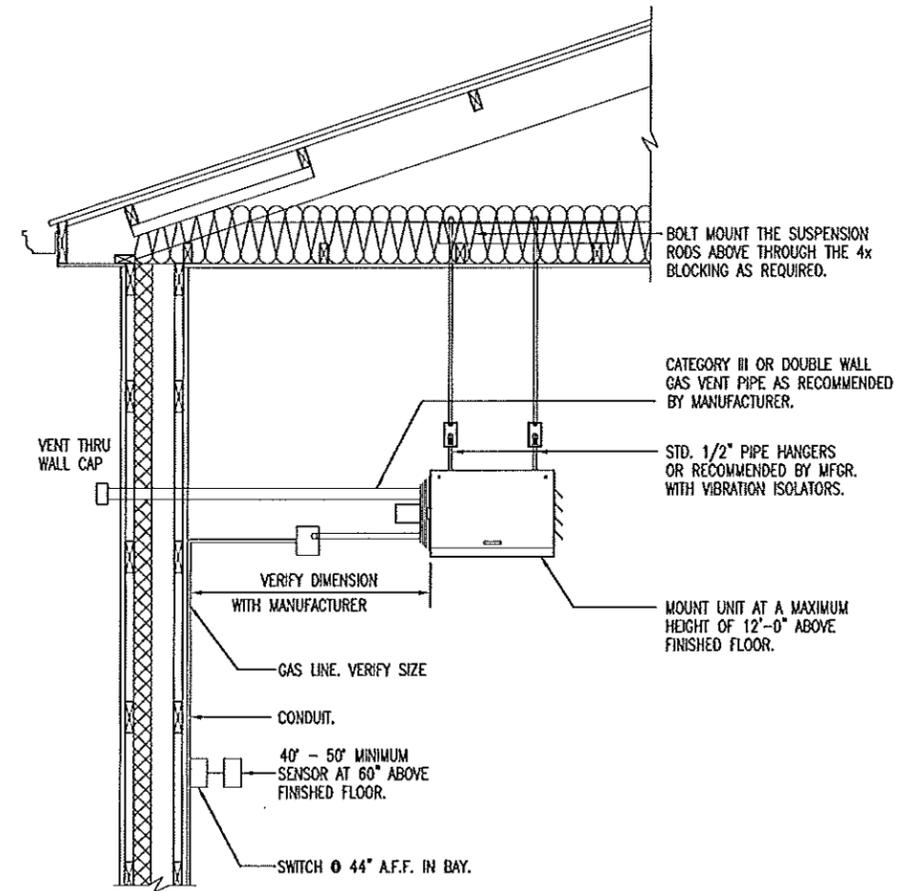

**B** UNIT HEATER INSTALLATION  
NOT TO SCALE

*Douglas A. Record*  
DOUGLAS A. RECORD  
NUMBER A-2009002624  
ARCHITECT

4/23/14

## MECHANICAL PLAN

MISSOURI DEPARTMENT OF TRANSPORTATION  
DIVISION OF GENERAL SERVICES FACILITIES MANAGEMENT

New Pole Barn in Southeast District  
HAYTI, MISSOURI  
Pemiscot County

DRAWN BY: LARRY CARVER  
CHECKED BY: DOUG RECORD  
DATE: 4-22-14  
Sheet 12 of 14

**LEGEND**


- ⊞ WP SINGLE POLE SWITCH, MOUNT IN FS BOX W/ HUBBELL HBL 7420 COVER.
- ⊞ WP DUPLEX RECEPTACLE MOUNTED IN FS BOX WITH HUBBELL HBL5221 COVER.
- ⊞ WP SINGLE RECEPTACLE MOUNTED IN FS BOX WITH HUBBELL HBL7423 COVER.
- ⊞ 3-WAY SWITCH, FLUSH MOUNTED IN FINISHED AREAS @ 48" A.F.F.

- ⊞ WELDER RECEPTACLE SURFACE MOUNTED 42" A.F.F., MOUNT IN 4" SQUARE BOX WITH RAISED COVER.
- ⊞ NO FUSED DISCONNECT SWITCH.
- ⊞ FUSED DISCONNECT SWITCH.
- ⊞ JUNCTION BOX, SIZE FOR WIRE, FILL ACCORDING TO ARTICLE 314-16 OF THE N.E.C.

- #12 COPPER NEUTRAL CONDUCTOR UNLESS NOTED.
- #12 COPPER PHASE CONDUCTORS UNLESS NOTED.
- 1/2" EMT UNLESS NOTED.
- #12 COPPER GROUNDING CONDUCTOR UNLESS NOTED.


CONNECTION TO POWER POLE APPROXIMATELY 180' NEAR THE SOUTHWEST CORNER OF THE ASPHALT CONTAINMENT TANK FOR A FUNCTIONAL SERVICE.

#4 BARE COPPER WIRE GROUND.  
(4) 5/8" X 10' COPPER GROUND RODS ON 8' CENTERS.

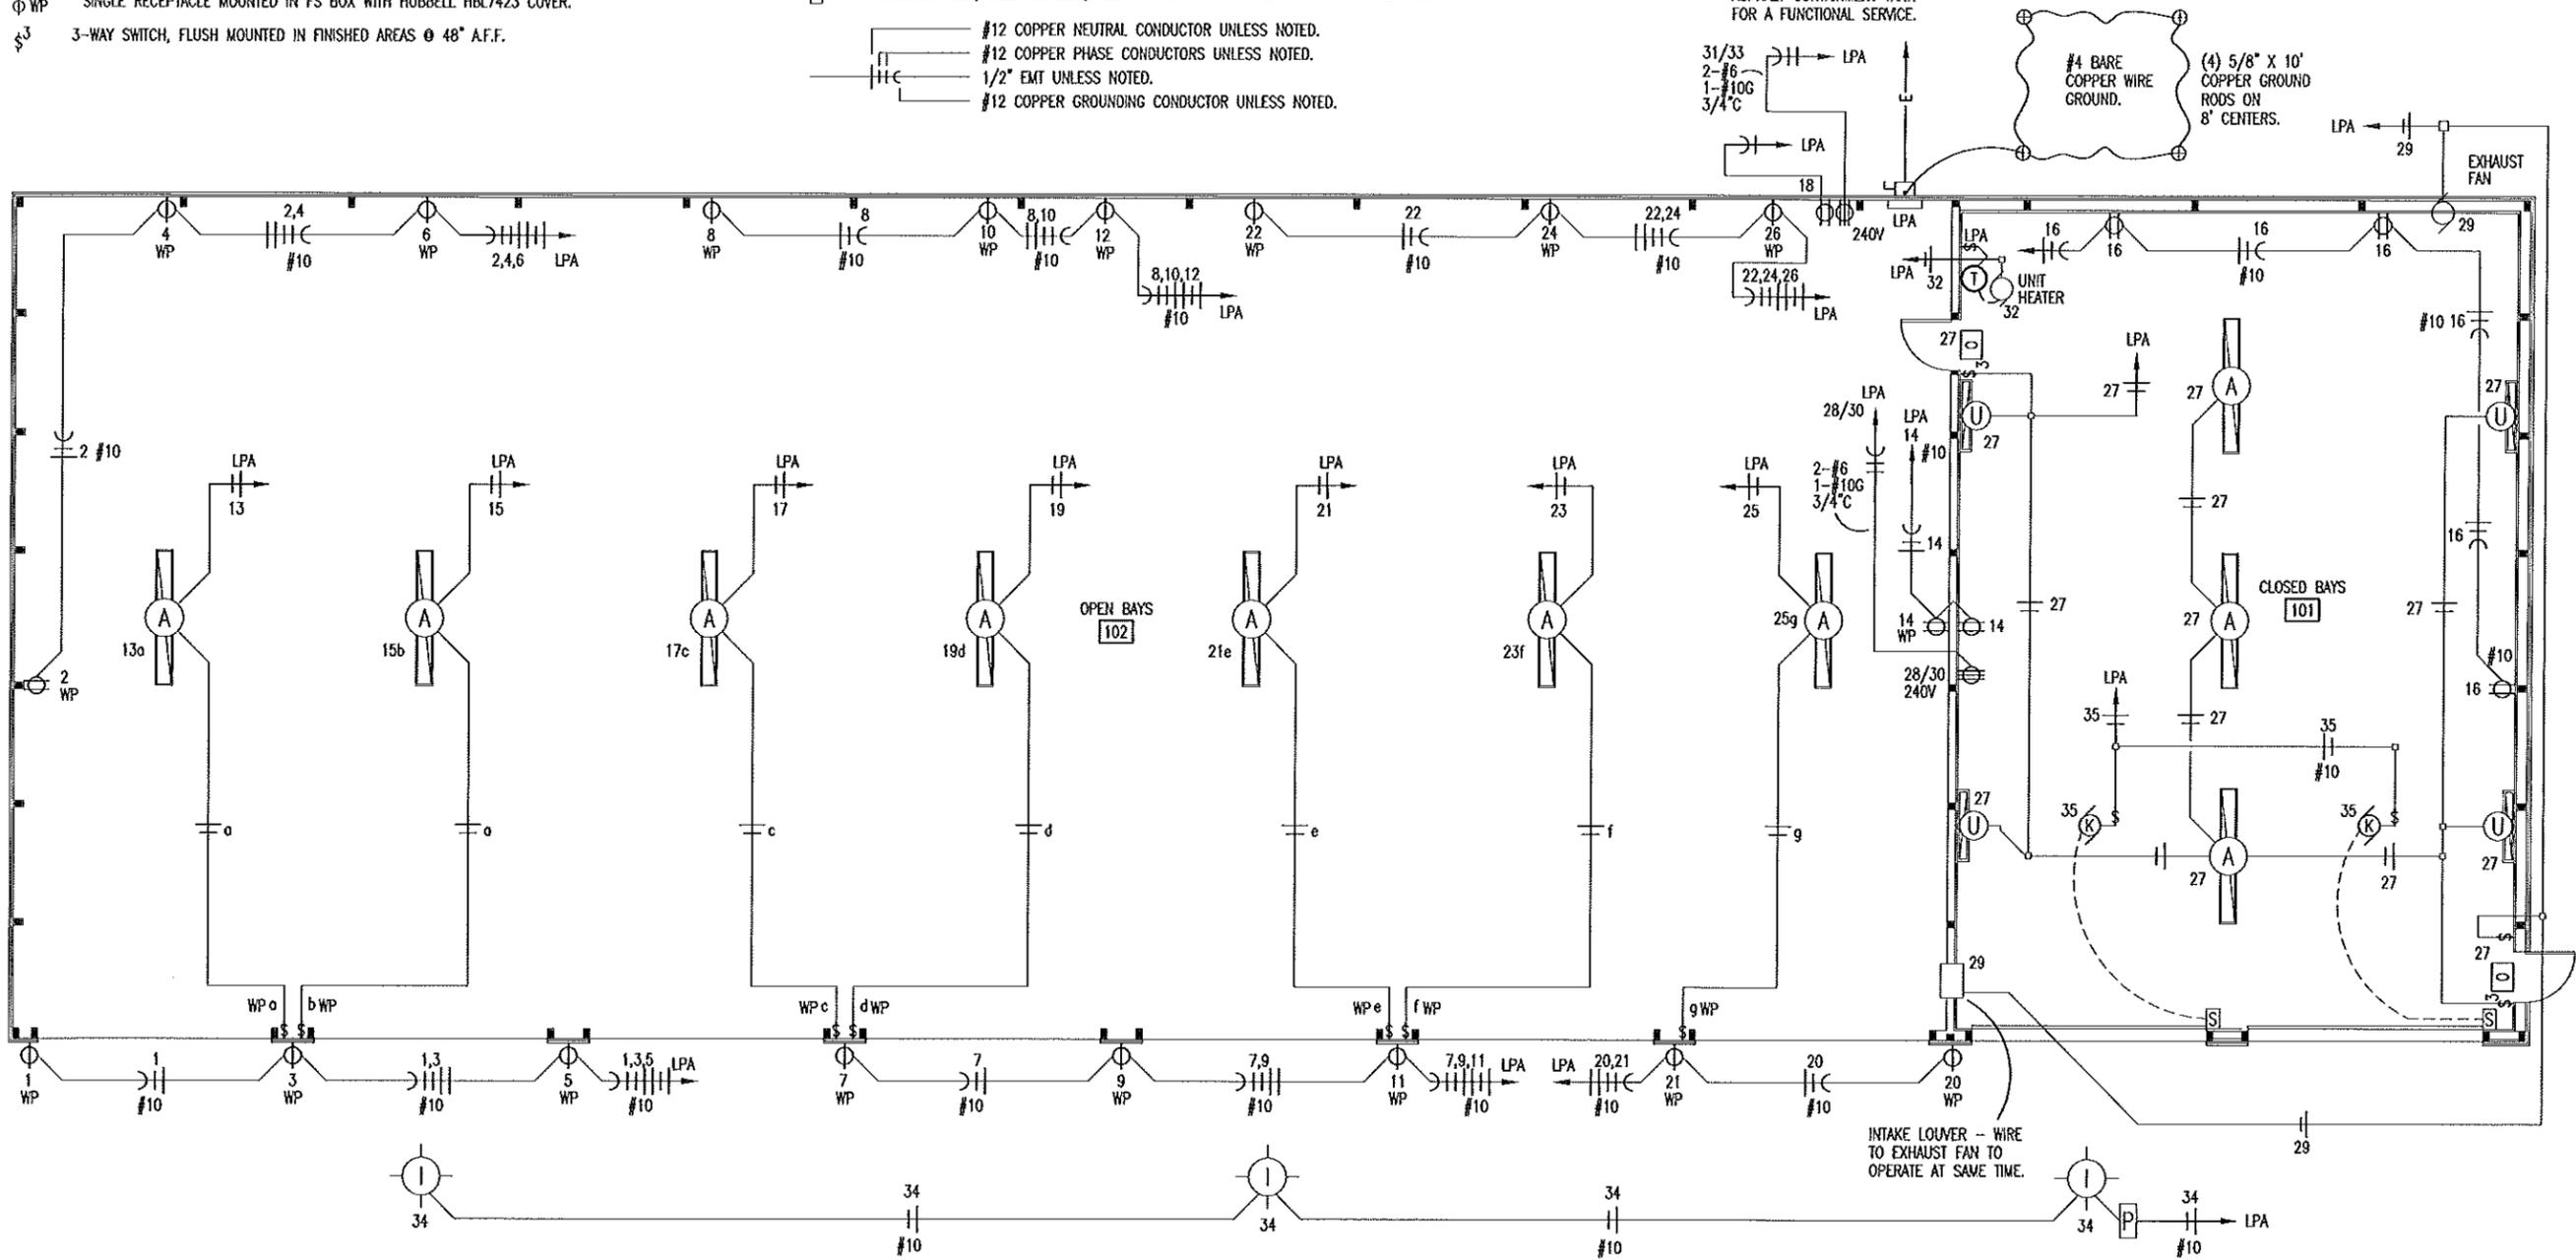

**A** ELECTRICAL PLAN  
13 SCALE: 3/32" = 1'-0"  
NORTH

SEE ELECTRIC SCHEDULE SHEET 14.

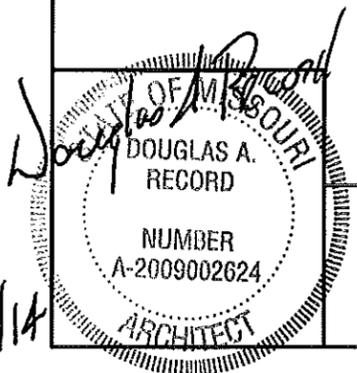

**ELECTRICAL PLAN**

MISSOURI DEPARTMENT OF TRANSPORTATION  
DIVISION OF GENERAL SERVICES  
FACILITIES MANAGEMENT

New Pole Barn in Southeast District  
HAYTI, MISSOURI  
Pemiscot County

DRAWN BY: LARRY CARYER
CHECKED BY: DOUG RECORD
DATE: 4-22-14
Sheet 13 of 14

ELECTRIC SCHEDULE						
MANUF.	MODEL	#	LAMPS TYPE	W	MOUNT	REMARKS
WILLIAMS ⓐ	81-8-454TSH-WG-EB2-UNV	4	FLOURESCENT	54	CLG	96" LONG SURFACE MOUNT FLUORESCENT LIGHT FIXTURE, W/ PAINTED STEEL HOUSING, ELECTRONIC BALLAST, & WIRE GUARD.
LITHONIA ⓑ	TWR1 LED 1 50K MVOLT	1	LED	35	WALL	RUGGED CAST ALUMINUM WITH BRONZE POWDER PAINT. ONE PIECE GASKET TO INHIBIT THE ENTRANCE OF EXTERNAL CONTAMINATES.
	OVERHEAD DOOR OPERATOR				WALL	115V, 1-PH, TROLLEY TYPE. SEE SPECIFICATION SECTION 08720.
LITHONIA Ⓒ	LHQM P W3 R N				WALL	QUANTUM THERMOPLASTIC EXIT/UNIT COMBO (2) LED 5.4 KRYPTON LAMPS.
TORK Ⓓ	2001				WALL	120V PHOTO ELECTRIC CONTROL OF EXTERIOR LIGHTS.
	OVERHEAD DOOR CONTROL				WALL	THREE BUTTON OVERHEAD DOOR CONTROL AS SUPPLIED BY OVERHEAD DOOR MANUF. SEE SPECIFICATION SECTION 08720.
LITHONIA Ⓔ	WC-2-28-T5-A12-MVOLT-GE810PS	2	FLUORESCENT	28	WALL	48" LENGTH x 4-5/8" WIDTH x 4-9/16" DEPTH, COMMERCIAL WALL BRACKET. PROVIDES UP/DOWN DISTRIBUTION. MOUNT 7'-0" A.F.F.


ELECTRICAL FIXTURES AND EQUIPMENT ARE SCHEDULED BY MANUFACTURER AND MODEL NUMBER FOR DESIGN INTENT ONLY, APPROVED EQUALS MAY BE SUBSTITUTED.

SERVICE PANEL LPA								
MAIN BUS: 225A MLO VOLTS: 240/120, 1PH, 3-WIRE BUS MATERIAL: COPPER MOUNTING: SURFACE		SQUARE "D" NQOD OR EQUAL W/ NEUTRAL BUS & GROUNDING BUS CIRCUIT BREAKERS BOLT-IN 10000 AIC		CONNECTED LOAD A PHASE 20623 VA B PHASE 23087 VA TOTAL 43710 VA 182 A				
CIR	SERVICE	VA	BKR		BKR	VA	SERVICE	CIR
1	EXTERIOR - RECEPTACLE ⓐ	1000	20A1P	A	20A1P	180	RECEPTACLES	2
3	EXTERIOR - RECEPTACLE ⓐ	1000	20A1P	B	20A1P	1000	RECEPTACLES	4
5	EXTERIOR - RECEPTACLE ⓐ	1000	20A1P	A	20A1P	1000	RECEPTACLES	6
7	EXTERIOR - RECEPTACLE ⓐ	1000	20A1P	B	20A1P	1000	RECEPTACLES	8
9	EXTERIOR - RECEPTACLE ⓐ	1000	20A1P	A	20A1P	1000	RECEPTACLES	10
11	EXTERIOR - RECEPTACLE ⓐ	1000	20A1P	B	20A1P	1000	RECEPTACLES	12
13	LIGHTS	432	20A1P	A	20A1P	360	RECEPTACLES	14
15	LIGHTS	432	20A1P	B	20A1P	540	RECEPTACLES	16
17	LIGHTS	432	20A1P	A	20A1P	483	COMPRESSOR DRYER	18
19	LIGHTS	432	20A1P	B	20A1P	1000	EXTERIOR - RECEPTACLE ⓐ	20
21	EXTERIOR - RECEPTACLE ⓐ	1000	20A1P	A	20A1P	1000	RECEPTACLES	22
23	LIGHTS	432	20A1P	B	20A1P	1000	RECEPTACLES	24
25	LIGHTS	432	20A1P	A	20A1P	1000	RECEPTACLES	26
27	LIGHTS	1521	20A1P	B	50A2P	4500	101 - WELDER	28
29	EXHAUST FAN & DAMPER	679	20A1P	A		4500		30
31	102 - AIR COMPRESSOR	4600	50A2P	B	15A1P	468	UNIT HEATER	32
33		4600		A	20A1P	525	EXTERIOR LIGHTS	34
35	GARAGE DOOR OPENERS	2162	30A1P	B				36
37				A				38
39				B				40
41				A				42

ⓐ CIRCUIT BREAKER SHALL BE GFI RATED

**ELECTRICAL NOTES**

- DRAWINGS AND DIAGRAMS ARE DIAGRAMMATIC AND SHALL NOT BE SCALED. REFER TO ARCHITECTURAL DRAWINGS FOR DIMENSIONS.
- ELECTRICAL WORK SHALL BE INSTALLED IN STRICT COMPLIANCE WITH THE LATEST EDITION OF THE NATIONAL ELECTRIC CODE (N.E.C.).
- PROVIDE ELECTRICAL EQUIPMENT AND ACCESSORIES REQUIRED FOR A COMPLETE AND OPERATIONAL ELECTRICAL SYSTEM AS REQUIRED BY MANUFACTURER'S INSTRUCTIONS AND DIRECTIONS FOR SYSTEMS SPECIFIED.
- SWITCHES AND RECEPTACLES SHALL BE EQUAL TO THE AMPERE RATING SHOWN IN THE PANEL SCHEDULE. RECEPTACLES SHALL BE GROUND-FAULT INTERRUPTION TYPE WHERE SHOWN OR AS REQUIRED BY CODE.
- ALL RECEPTACLES IN BAY AREA TO BE MOUNTED AT 48" A.F.F.
- COORDINATE WORK WITH OTHER TRADES PRIOR TO COMMENCING WITH ELECTRICAL WORK.
- CONDUCTOR AND BREAKER SIZE MAY VARY PER MANUFACTURER ON THE EQUIPMENT SPECIFIED. ELECTRIC CONTRACTOR TO VERIFY SIZES WITH EXACT EQUIPMENT ORDERED PRIOR TO PURCHASING ELECTRICAL SUPPLIES.
- FIXTURE LOCATIONS ARE APPROXIMATE, EXACT LOCATIONS TO BE DETERMINED AFTER COLLABORATION WITH THE OWNER AND OTHER TRADES.
- CONTRACTOR SHALL PROVIDE SERVICE DISCONNECTS AS REQUIRED AT EXTERIOR OF BUILDING.
- PROVIDE BLOCKING FOR ELECTRICAL DEVICES AS REQUIRED FOR A SECURE APPLICATION.
- SEE SPECIFICATION SECTION 16100 - ELECTRICAL FOR ADDITIONAL REQUIREMENTS.
- CONTRACTOR TO INSTALL CONDUCTORS IN CONDUIT FROM POWER POLE UP TO SERVICE DISCONNECT AND THEN TO INSIDE FOR A FUNCTIONAL SYSTEM. PROVIDE AND INSTALL METER AS/IF REQUIRED.

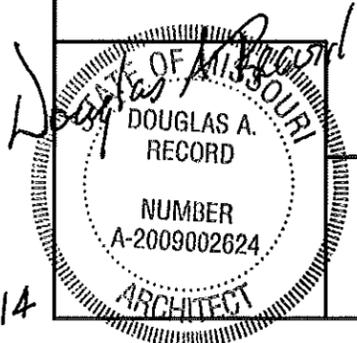

**ELECTRICAL PANEL**

MISSOURI DEPARTMENT OF TRANSPORTATION  
DIVISION OF GENERAL SERVICES FACILITIES MANAGEMENT

New Pole Barn in Southeast District  
HAYTI, MISSOURI  
Pemiscot County

DRAWN BY: LARRY CARVER  
CHECKED BY: DOUG RECORD  
DATE: 4-22-14  
Sheet 14 of 14